
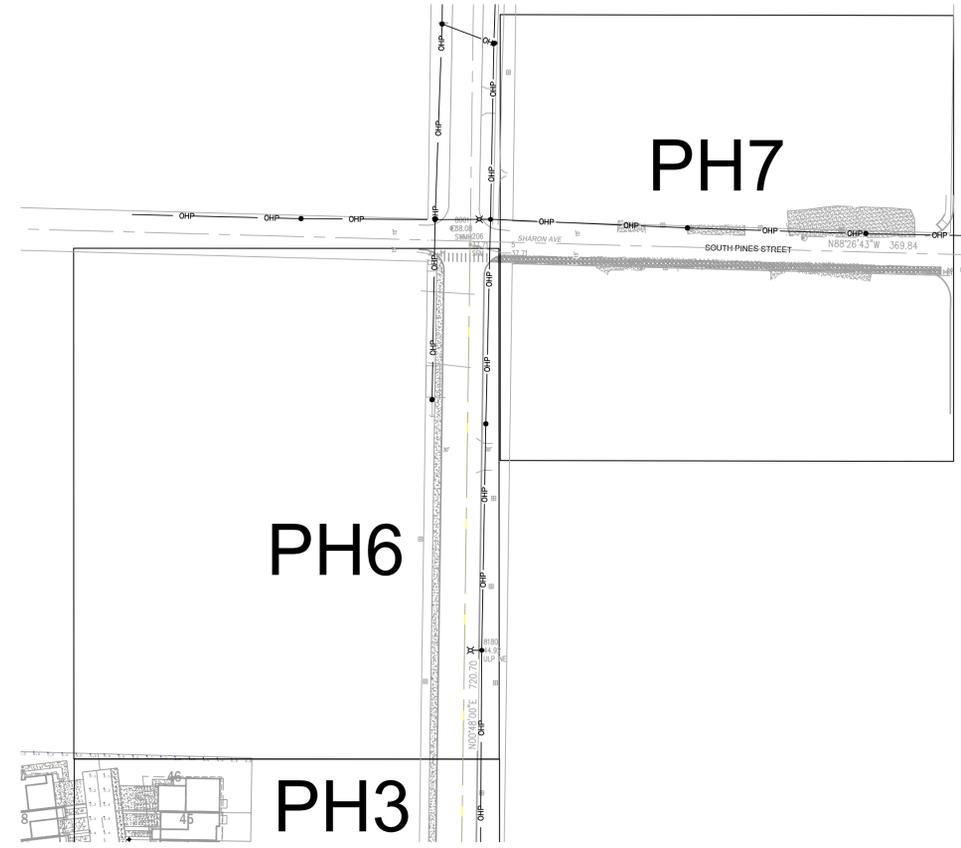


Plotted By: Netenbock, David Sheet: Set: KHA Layout: PH 2 July 05, 2023 12:49:54pm \\sno\p01\mnt_sno\SNO_IPTO_2022\22-333 Gages Crossing Burlington\Site Plan\Plansheets\PH_090222333.dwg
 This document, together with the concepts and designs presented herein, is intended only for the specific purpose and client for which it was prepared. Reuse of and improper reliance on this document without written authorization and adaptation by Kimley-Horn and Associates, Inc. shall be without liability to Kimley-Horn and Associates, Inc.

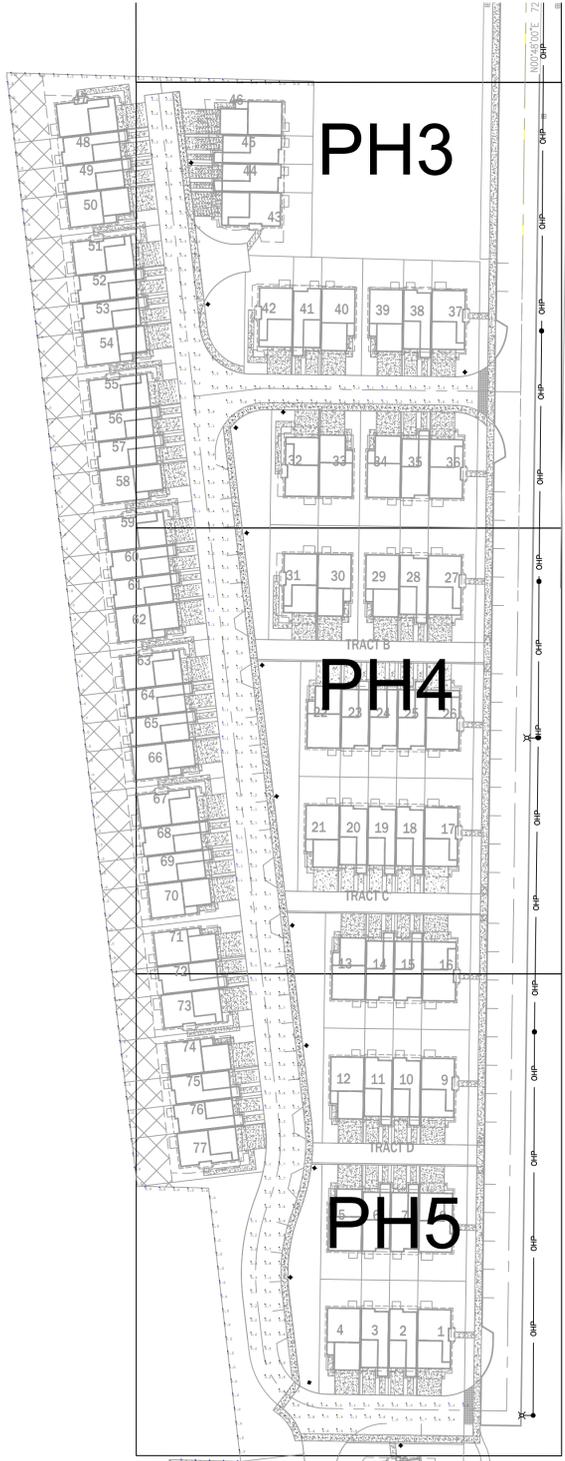


LUMINAIRE SCHEDULE							
SYMBOL	QUANTITY	STYLE	MANUFACTURER AND CATALOG NUMBER	WATTS	LUMENS	LAMP	LAMP HEIGHT
	14	POST TOP	AEL - 247CL-P101-MVOLT-40K-R3-HSS	20	2440	LED	14'-0"

LIGHTING CRITERIA	
AREA	MAXIMUM (fc)
ROAD	5.00
PROPERTY LINE	0.1

PHOTOMETRIC ANALYSIS				
AREA	AVERAGE (fc)	MINIMUM (fc)	MAXIMUM (fc)	UNIFORMITY AVE/MIN
ROAD	0.53	0.10	1.70	5.30
SIDEWALK	0.68	0.00	1.50	N/A
PROPERTY LINE	0.00	0.00	0.00	N/A

 © 2023 KIMLEY-HORN AND ASSOCIATES, INC. 4582 South Ulster St., SUITE 1500 PHOENIX, AZ 85042 PHONE: 602-228-2300 WWW.KIMLEY-HORN.COM	KHA PROJECT 090036000	DATE ---	SCALE AS SHOWN DESIGNED BY DSN DRAWN BY DSN CHECKED BY DJC	REVISIONS No. DATE BY
	GAGES CROSSING, BURLINGTON PHOTOMETRIC PLAN SKAGIT COUNTY WASHINGTON			
SHEET NUMBER PH2				


Plotted By: Netenbock, David Sheet: Set: KHA - Layout: PH 3 July 05, 2023 12:49:59pm \\sno\p01\mnt_sno\NO_TPTO_2022\22-333_Gages_Crossing_Burlington\Site Plan\Plotsheets\PH_090222333.dwg
 This document, together with the concepts and designs presented herein, is intended only for the specific purpose and client for which it was prepared. Reuse of and improper reliance on this document without written authorization and adaptation by Kimley-Horn and Associates, Inc. shall be without liability to Kimley-Horn and Associates, Inc.

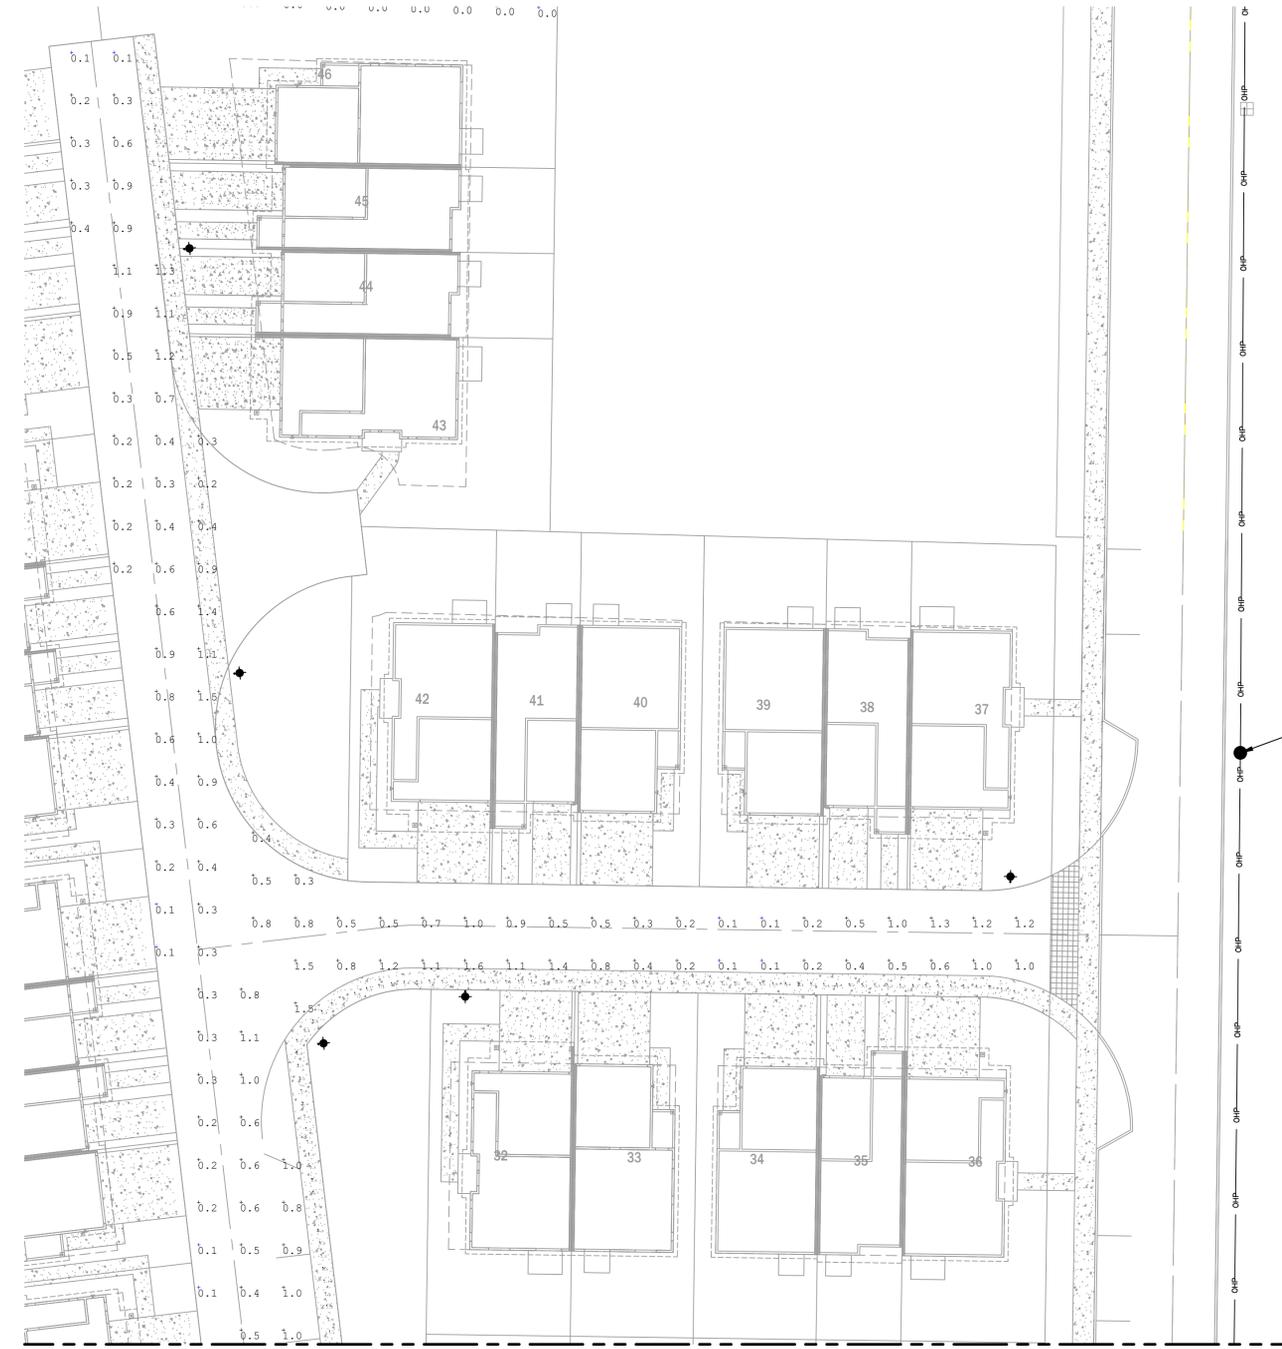

SEE SHEET PH 4

LEGEND

 247CL - POST TOP LUMINAIRE

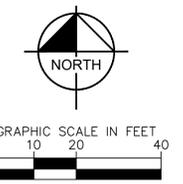

No.	REVISIONS	DATE	BY

Kimley»Horn
 © 2023 KIMLEY-HORN AND ASSOCIATES, INC.
 4582 South Durfee St., SUITE 1500
 PHOENIX, AZ 85044
 PHONE: 303-228-2300
 WWW.KIMLEY-HORN.COM

KHA PROJECT 090036000	DATE ---
SCALE AS SHOWN	DESIGNED BY DSN
DRAWN BY DSN	CHECKED BY DJC

**GAGES CROSSING,
 BURLINGTON
 PHOTOMETRIC PLAN**
 SKAGIT COUNTY WASHINGTON

SHEET NUMBER
PH3

Plotted By: Netenbock, David Sheet: Set: KHA - Layout: PH 4 July 05, 2023 12:49:59pm \\sno\p01\mnt_sno\NO_TPTO_2022\22-333 Gages Crossing Burlington\Site Plan\PlanSheets\PH_090222333.dwg
 This document, together with the concepts and designs presented herein, is intended only for the specific purpose and client for which it was prepared. Reuse of and improper reliance on this document without written authorization and adaptation by Kimley-Horn and Associates, Inc. shall be without liability to Kimley-Horn and Associates, Inc.




LEGEND

 247CL - POST TOP LUMINAIRE

 POWER POLE WITHOUT LIGHT

 POWER POLE WITH LIGHT

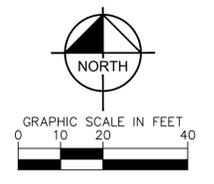

No.	REVISIONS	DATE	BY

Kimley»Horn
 © 2023 KIMLEY-HORN AND ASSOCIATES, INC.
 4582 South Usher St., Suite 1500
 Phone: 303-228-2300
 WWW.KIMLEY-HORN.COM


KHA PROJECT	090036000
DATE	---
SCALE	AS SHOWN
DESIGNED BY	DSN
DRAWN BY	DSN
CHECKED BY	DJC

**GAGES CROSSING,
 BURLINGTON**
 PHOTOMETRIC PLAN

SKAGIT COUNTY WASHINGTON

SHEET NUMBER
PH4

Plotted By: Netenbock, David Sheet: Set: KHA - Layout: PH 5 July 05, 2023 12:50:01pm \\sno\p01\mnt_sno\p01\p01\2022\22-333 Gages Crossing Burlington Site Plan\Plansheets\PH_090222333.dwg
 This document, together with the concepts and designs presented herein, is intended only for the specific purpose and client for which it was prepared. Reuse of and improper reliance on this document without written authorization and adaptation by Kimley-Horn and Associates, Inc. shall be without liability to Kimley-Horn and Associates, Inc.

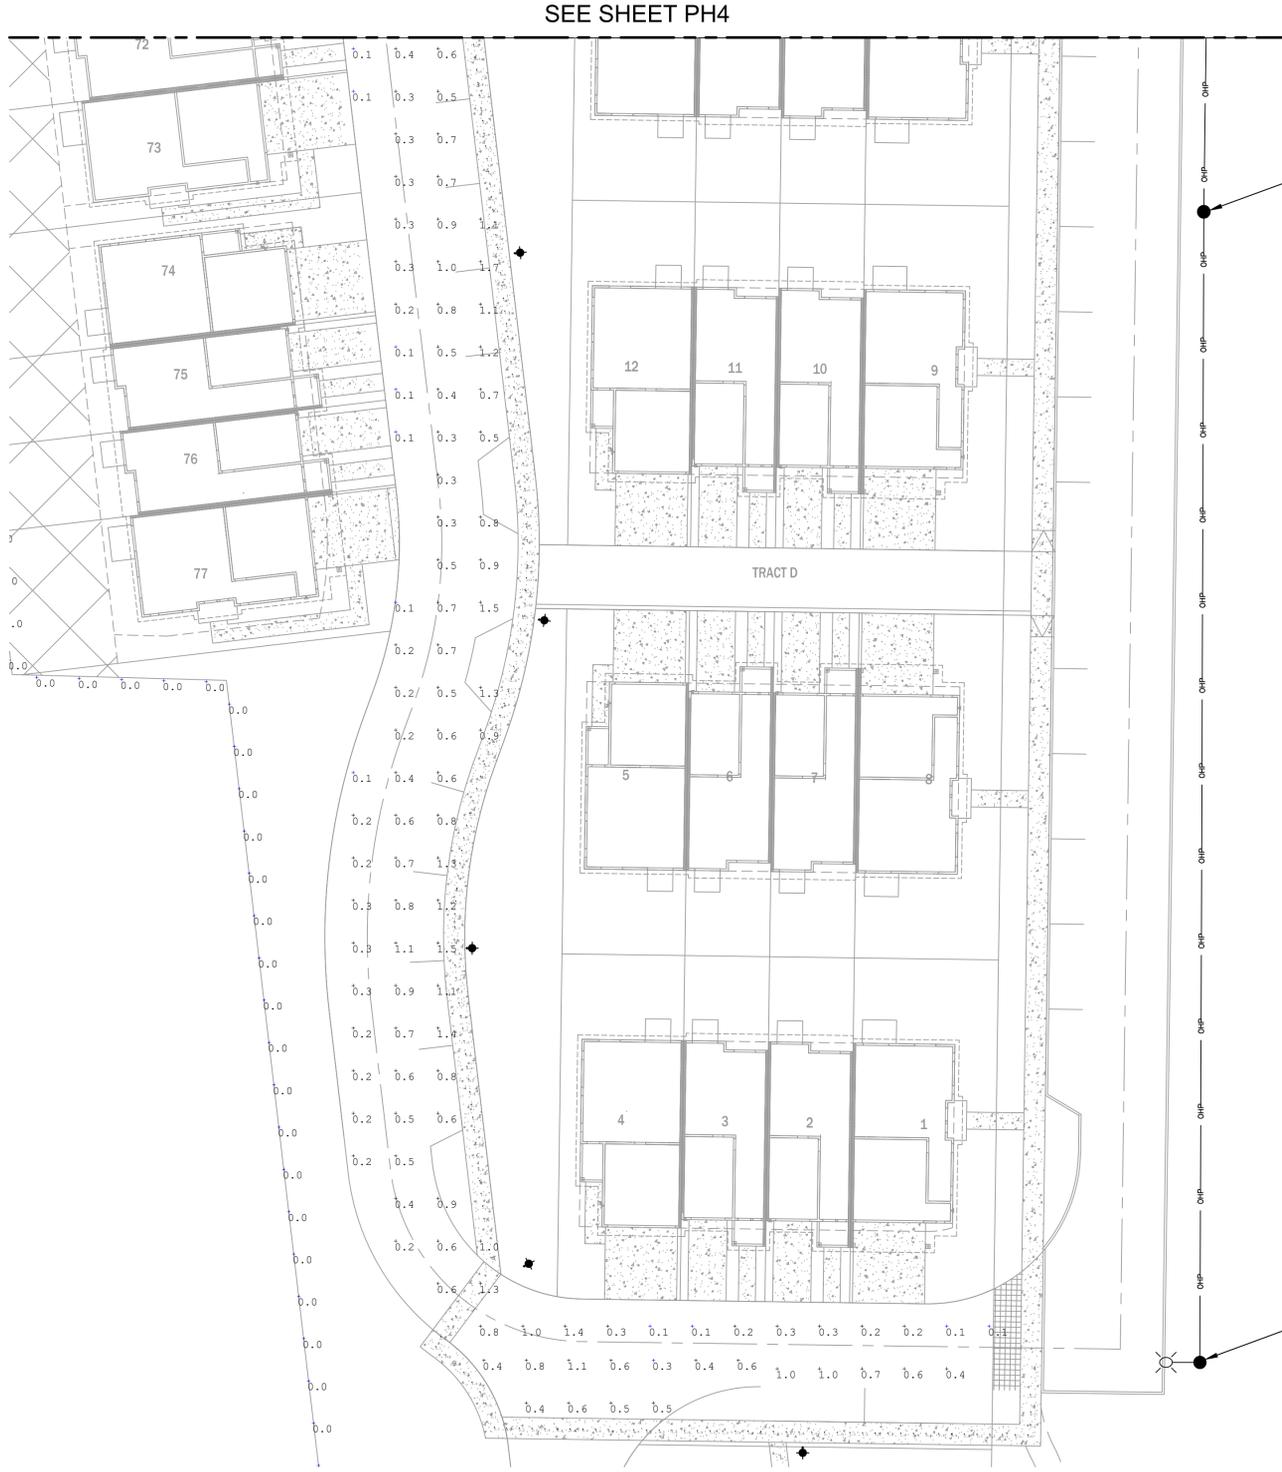


LEGEND

 247CL - POST TOP LUMINAIRE

 POWER POLE WITHOUT LIGHT

 POWER POLE WITH LIGHT

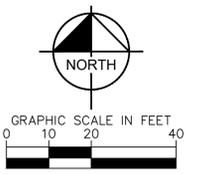

No.	REVISIONS	DATE	BY

Kimley»Horn
 © 2023 KIMLEY-HORN AND ASSOCIATES, INC.
 4582 South Usher St., Suite 1500
 Phone: 303-228-2300
 www.kimley-horn.com

KHA PROJECT 090036000
DATE ----
SCALE AS SHOWN
DESIGNED BY DSN
DRAWN BY DSN
CHECKED BY DJC

**GAGES CROSSING,
 BURLINGTON
 PHOTOMETRIC PLAN**
 SKAGIT COUNTY WASHINGTON

SHEET NUMBER
PH5

